
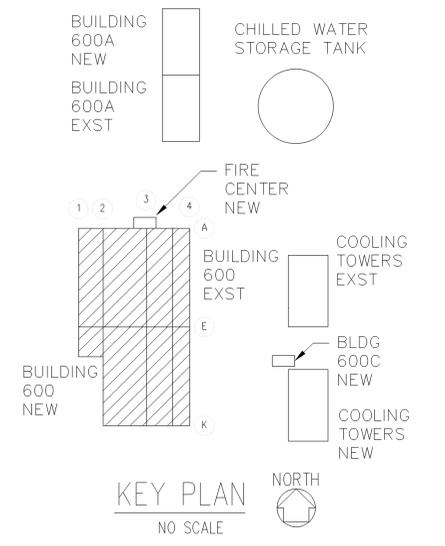


Date (mm dd yyyy)	Issued For	Rev.
12-07-2007	TITLE II DESIGN 30% REVIEW SUBMITTAL	C
03-28-2008	TITLE II DESIGN 60% REVIEW SUBMITTAL	D
07-31-2008	TITLE II DESIGN 90% REVIEW SUBMITTAL	E
08-25-2008	TITLE II DESIGN 100% OWNER REVIEW	F
02-19-2009	TITLE II CONSTRUCTION BID ISSUE	0

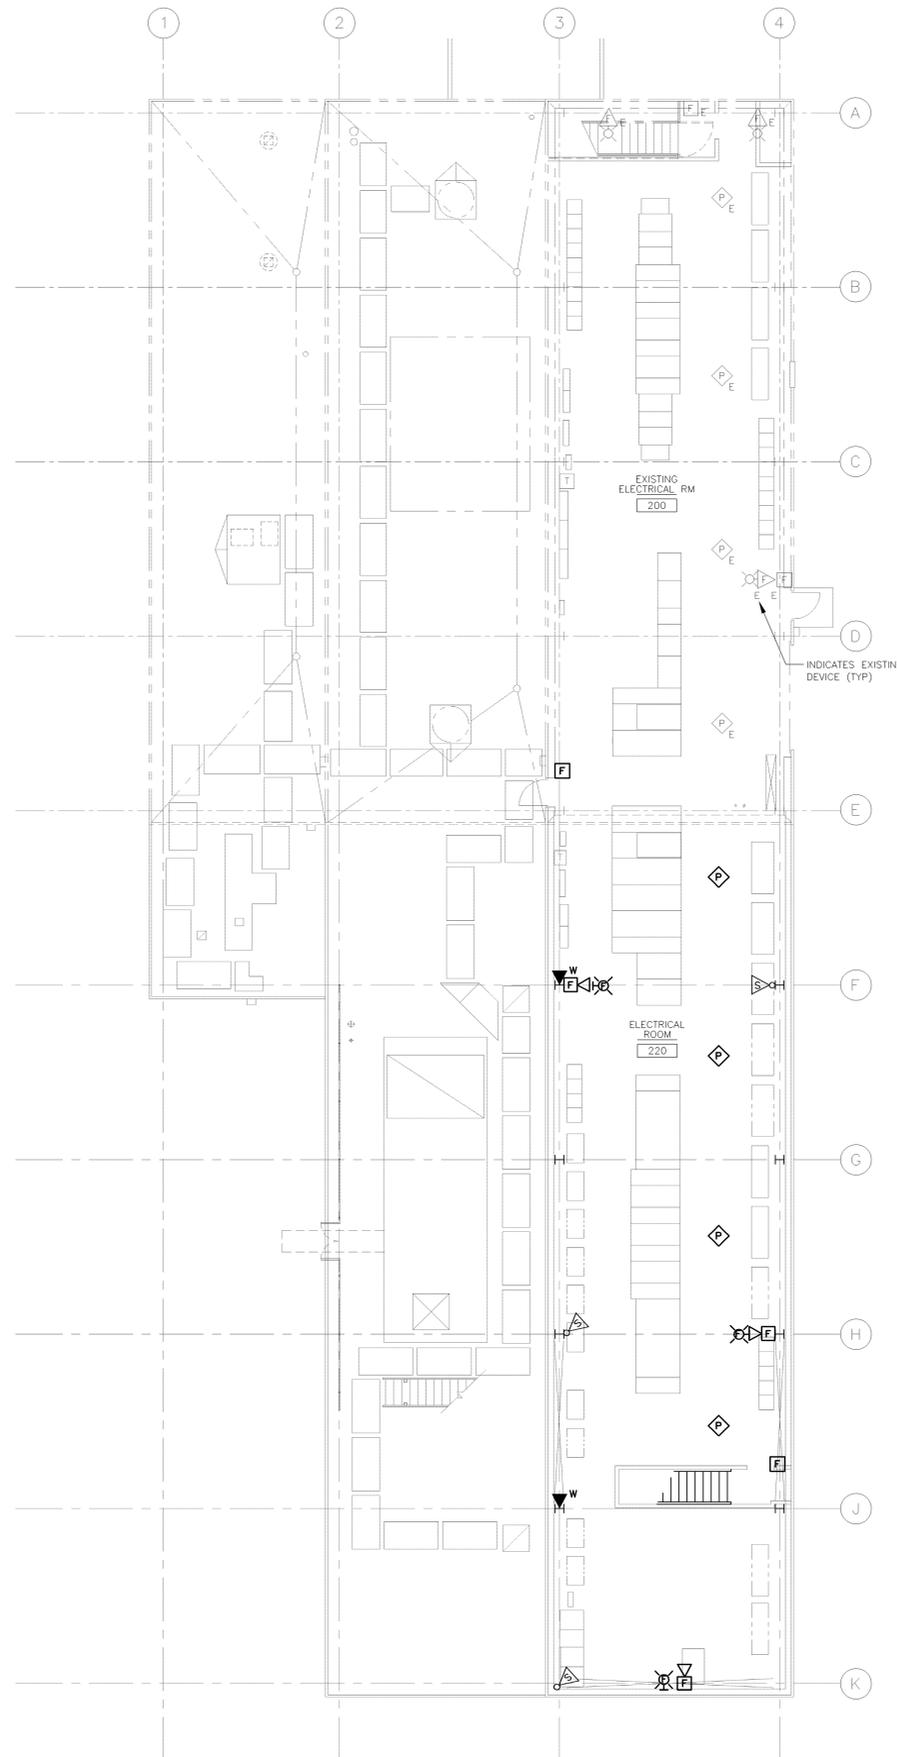

BUILDING 600 AUX SYS ELECTRICAL RM
1/8"=1'-0"

- AUXILIARY SYSTEM GENERAL NOTES:**
1. REFER TO DRAWING E-001 FOR ELECTRICAL ABBREVIATIONS, GENERAL NOTES AND DRAWING LIST AND DRAWING E-002 FOR ELECTRICAL SYMBOLS.
 2. SEE DRAWING E-608 FOR FIRE ALARM RISER DIAGRAM.
 3. SEE DRAWING E-609 FOR PAGING SYSTEM RISER DIAGRAM.
 4. SEE DRAWING E-611 FOR TELEPHONE SYSTEM RISER DIAGRAM.
 5. SEE DRAWING E-506 FOR AUXILIARY SYSTEM DETAILS.
 6. COORDINATE MOUNTING HEIGHTS OF FIRE ALARM DEVICES AND PAGING SPEAKERS WITH MECHANICAL PIPING AND EQUIPMENT. COORDINATE ANY MOUNTING OBSTRUCTION WITH OWNER REPRESENTATIVE. TYPICAL FOR FLOOR LEVEL.

This drawing has been prepared solely for the use of Brookhaven National Laboratory and there are no representations of any kind made by Giffels, Partnership to any party with whom Giffels, Partnership has not entered into a contract.

This drawing shall not be used for construction purposes until the seal and signature of the responsible registrant appears on the drawing and proper permit forms and related fees are transmitted by the Owner, Owner's Agent or Contractor to the Authority Having Jurisdiction.

Giffels, Partnership
25200 Telegraph Road, Suite 200
Southfield, Michigan 48033 USA
Tel: 248-936-8000
Fax: 248-936-8111

Approved By: R. BARTOY
Project Manager: G. KAPLAN
Project Engineer/Architect: R. WACK
Project No.: SF070003

JOB NO. SHEET NO. REVISION		DATE	DWG.	APPR.	ISA
BROOKHAVEN NATIONAL LABORATORY					
UNDER CONTRACT WITH UNITED STATES DEPARTMENT OF ENERGY PLANT ENGINEERING DIVISION UPTON, NEW YORK 11973					
JOB TITLE CENTRAL CHILLED WATER FACILITY PHASE II			DWG. TITLE AUX SYS PLAN ELECTRICAL MEZZ		
DATE	DATE	ACCT. NO.	SHEET OF		
SCALE 1/8" = 1'-0"	DWN. BY EA	REV'D BY RM	JOB NO. 11705	DWG. NO.	
ES&H RISK LEVEL	APPR. BY R. BARTOY	BLDG. NO. 600	EY-102		
PATH:					