
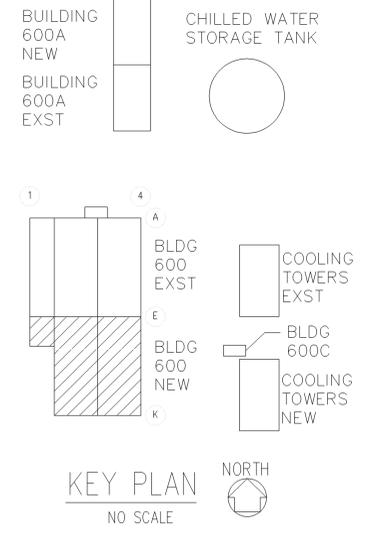


Date (mm dd yyyy)	Issued For	Rev.
09-21-2007	TITLE 1 60% REVIEW	A
10-24-2007	TITLE 1 100% COMPLETE	B
12-07-2007	TITLE II DESIGN 30% REVIEW SUBMITTAL	C
03-28-2008	TITLE II DESIGN 60% REVIEW SUBMITTAL	D
07-31-2008	TITLE II DESIGN 90% REVIEW SUBMITTAL	E
08-25-2008	TITLE II DESIGN 100% OWNER REVIEW	F
02-19-2009	TITLE II CONSTRUCTION BID ISSUE	G

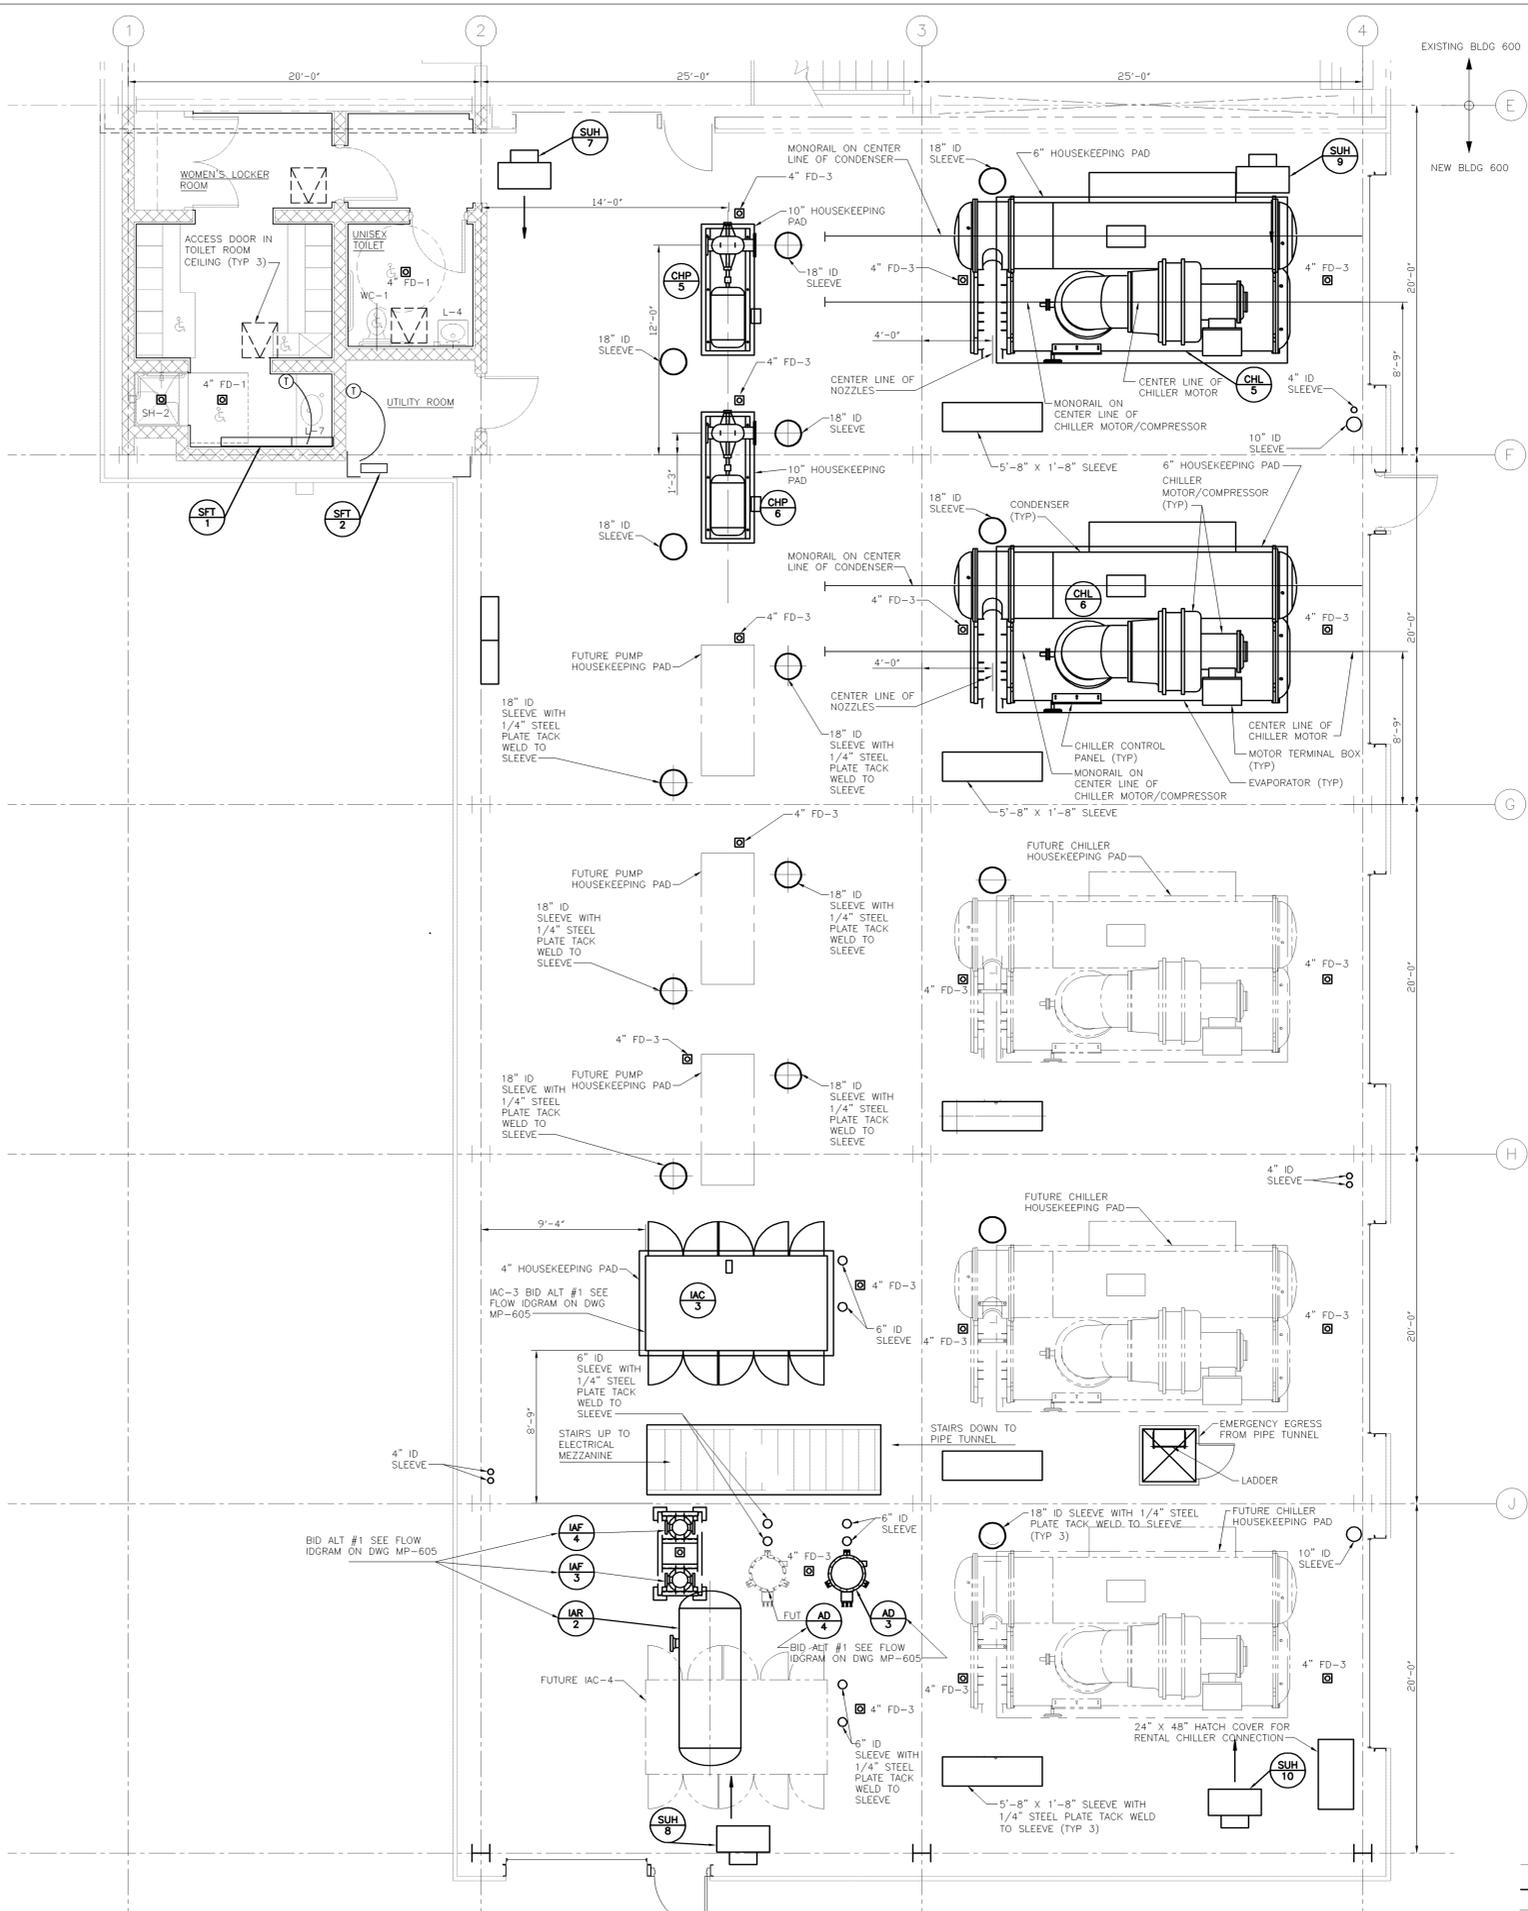

This drawing has been prepared solely for the use of Brookhaven National Laboratory and there are no representations of any kind made by Giffels, Partnership to any party with whom Giffels, Partnership has not entered into a contract.

This drawing shall not be used for construction purposes until the seal and signature of the responsible registrant appears on the drawing and proper permit forms and related fees are transmitted by the Owner, Owner's Agent or Contractor to the Authority Having Jurisdiction.

101A BUILDING 600 - OPERATING FLOOR PLAN
1/4" = 1'-0" FIN FL EL = 77'-0"

Giffels, Partnership
25200 Telegraph Road, Suite 200
Southfield, Michigan 48033 USA
Tel: 248-936-8000
Fax: 248-936-8111

Approved By: B. NEWMAN
Project Manager: G. KAPLAN
Project Engineer/Architect: E. FIENZEL
Project No.: SF070003

JOB NO.	SHEET NO.	REVISION	DATE	ENL.	APPD.	DLA.
BROOKHAVEN NATIONAL LABORATORY						
UNDER CONTRACT WITH UNITED STATES DEPARTMENT OF ENERGY PLANT ENGINEERING DIVISION UPTON, NEW YORK 11973						
JOB TITLE CENTRAL CHILLED WATER FACILITY PHASE II			DWG. TITLE EQUIPMENT LOCATION PLAN			
IR/APP/PLN, NEW	DATE	ACCT. NO.	SHEET OF			
SCALE 1/4"=1'-0"	DWN. BY EP	REV'D BY BN	JOB NO. 11705	SHEET NO.		
ES&D RISK LEVEL	APP. BY B. HARRISON	BLDG. NO. 600	M-101			
PATH:						