
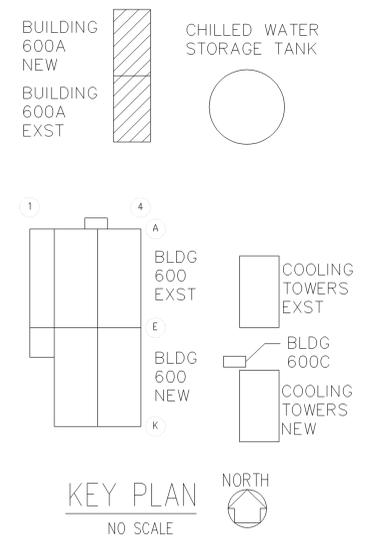


Date (mm dd yyyy)	Issued For	Rev.
09-21-2007	TITLE 1 60% REVIEW	A
10-24-2007	TITLE 1 100% COMPLETE	B
12-07-2007	TITLE II DESIGN 30% REVIEW SUBMITTAL	C
03-28-2008	TITLE II DESIGN 60% REVIEW SUBMITTAL	D
07-31-2008	TITLE II DESIGN 90% REVIEW SUBMITTAL	E
08-25-2008	TITLE II DESIGN 100% OWNER REVIEW	F
02-19-2009	TITLE II CONSTRUCTION BID ISSUE	G

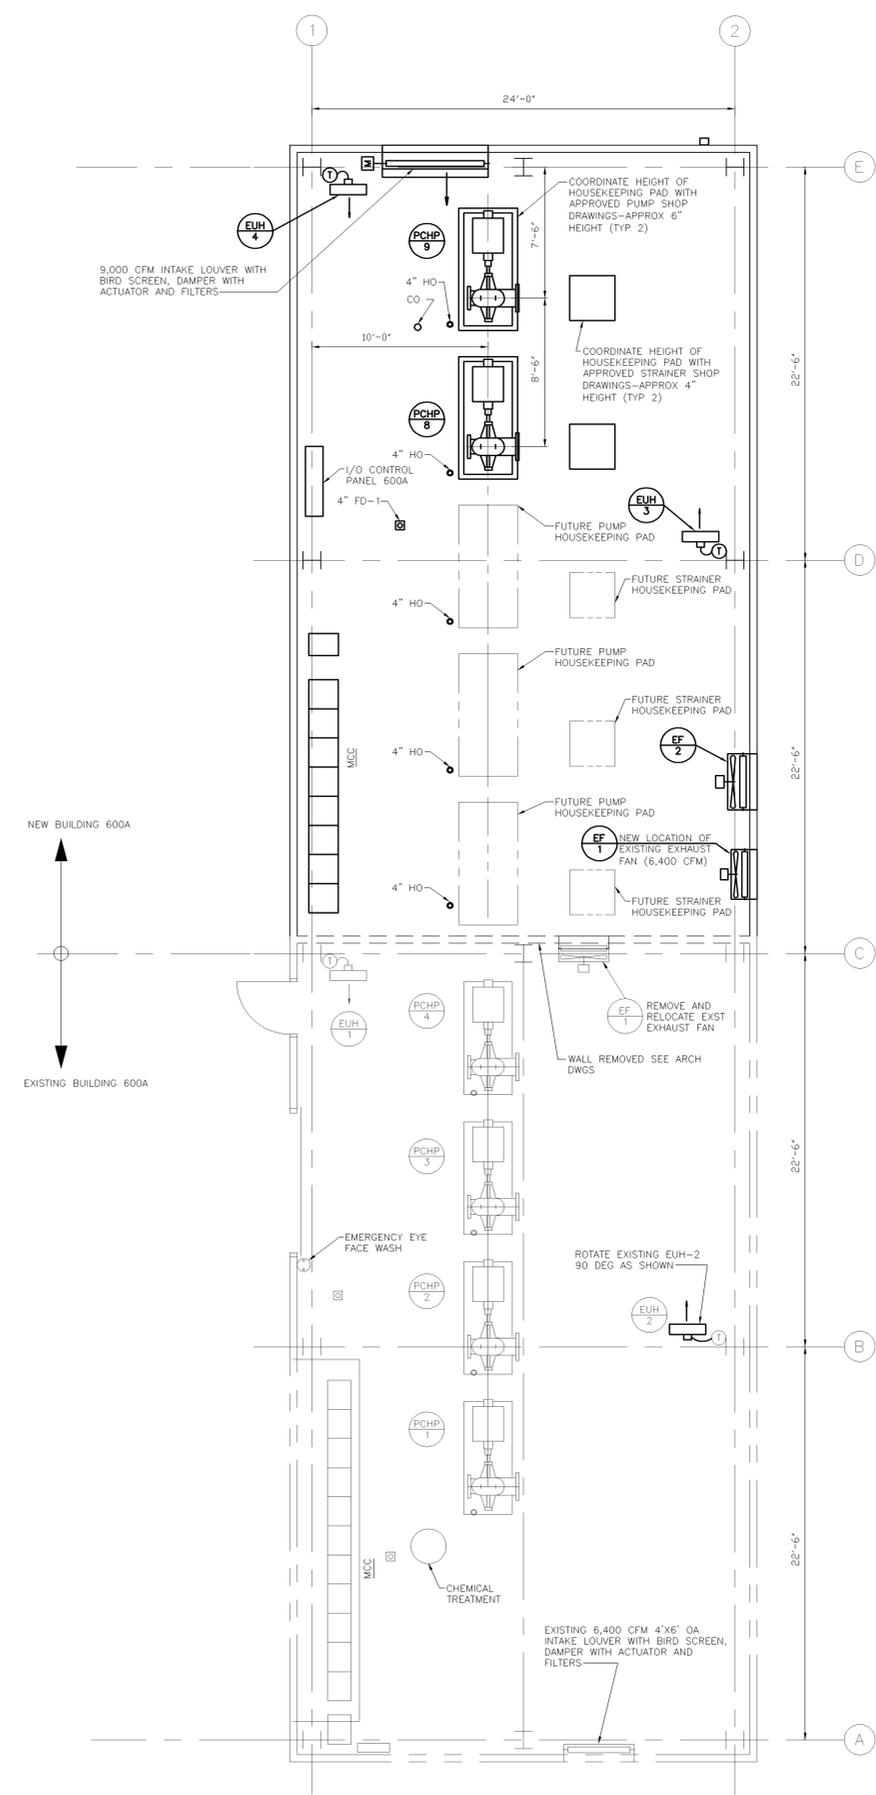

This drawing has been prepared solely for the use of Brookhaven National Laboratory and there are no representations of any kind made by Giffels, Partnership to any party with whom Giffels, Partnership has not entered into a contract.

This drawing shall not be used for construction purposes until the seal and signature of the responsible registrant appears on the drawing, and proper permit forms and related fees are transmitted by the Owner, Owner's Agent or Contractor to the Authority Having Jurisdiction.

**BUILDING 600A**  
**FLOOR PLAN**  
 104A  
 1/4" = 1'-0" FIN FL EL = 78'-0"

LEGEND

—	EXISTING
—	NEW
- - - -	FUTURE

**Giffels, Partnership**  
 25200 Telegraph Road, Suite 200  
 Southfield, Michigan 48033 USA  
 Tel: 248-936-8000  
 Fax: 248-936-8111

Approved By: B. NEWMAN  
 Project Manager: G. KAPLAN  
 Project Engineer/Architect: E. PENDEL  
 Project No.: SF070003

UNDER CONTRACT WITH <b>UNITED STATES DEPARTMENT OF ENERGY</b> PLANT ENGINEERING DIVISION UPTON, NEW YORK 11973	
JOB TITLE <b>CENTRAL CHILLED WATER FACILITY PHASE II</b>	DWG. TITLE <b>EQUIPMENT LOCATION PLAN</b>
IUR/APPLIC. NEW DATE SCALE 1/4"=1'-0" ESHQ RISK LEVEL APP. BY W. HARRISON	ACCT. NO. 11705 BLDG. NO. 600A SHEET OF M-103