
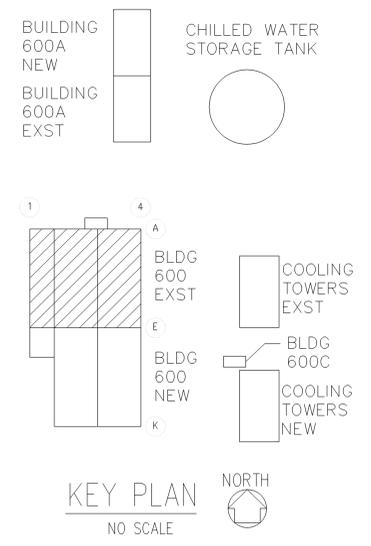


Date (mm-dd-yyyy)	Issued For	Rev.
09-21-2007	TITLE I 60% REVIEW	A
10-24-2007	TITLE I 100% COMPLETE	B
12-07-2007	TITLE II DESIGN 30% REVIEW SUBMITTAL	C
03-28-2008	TITLE II DESIGN 60% REVIEW SUBMITTAL	D
07-31-2008	TITLE II DESIGN 90% REVIEW SUBMITTAL	E
08-25-2008	TITLE II DESIGN 100% OWNER REVIEW	F
02-19-2009	TITLE II CONSTRUCTION BID ISSUE	G

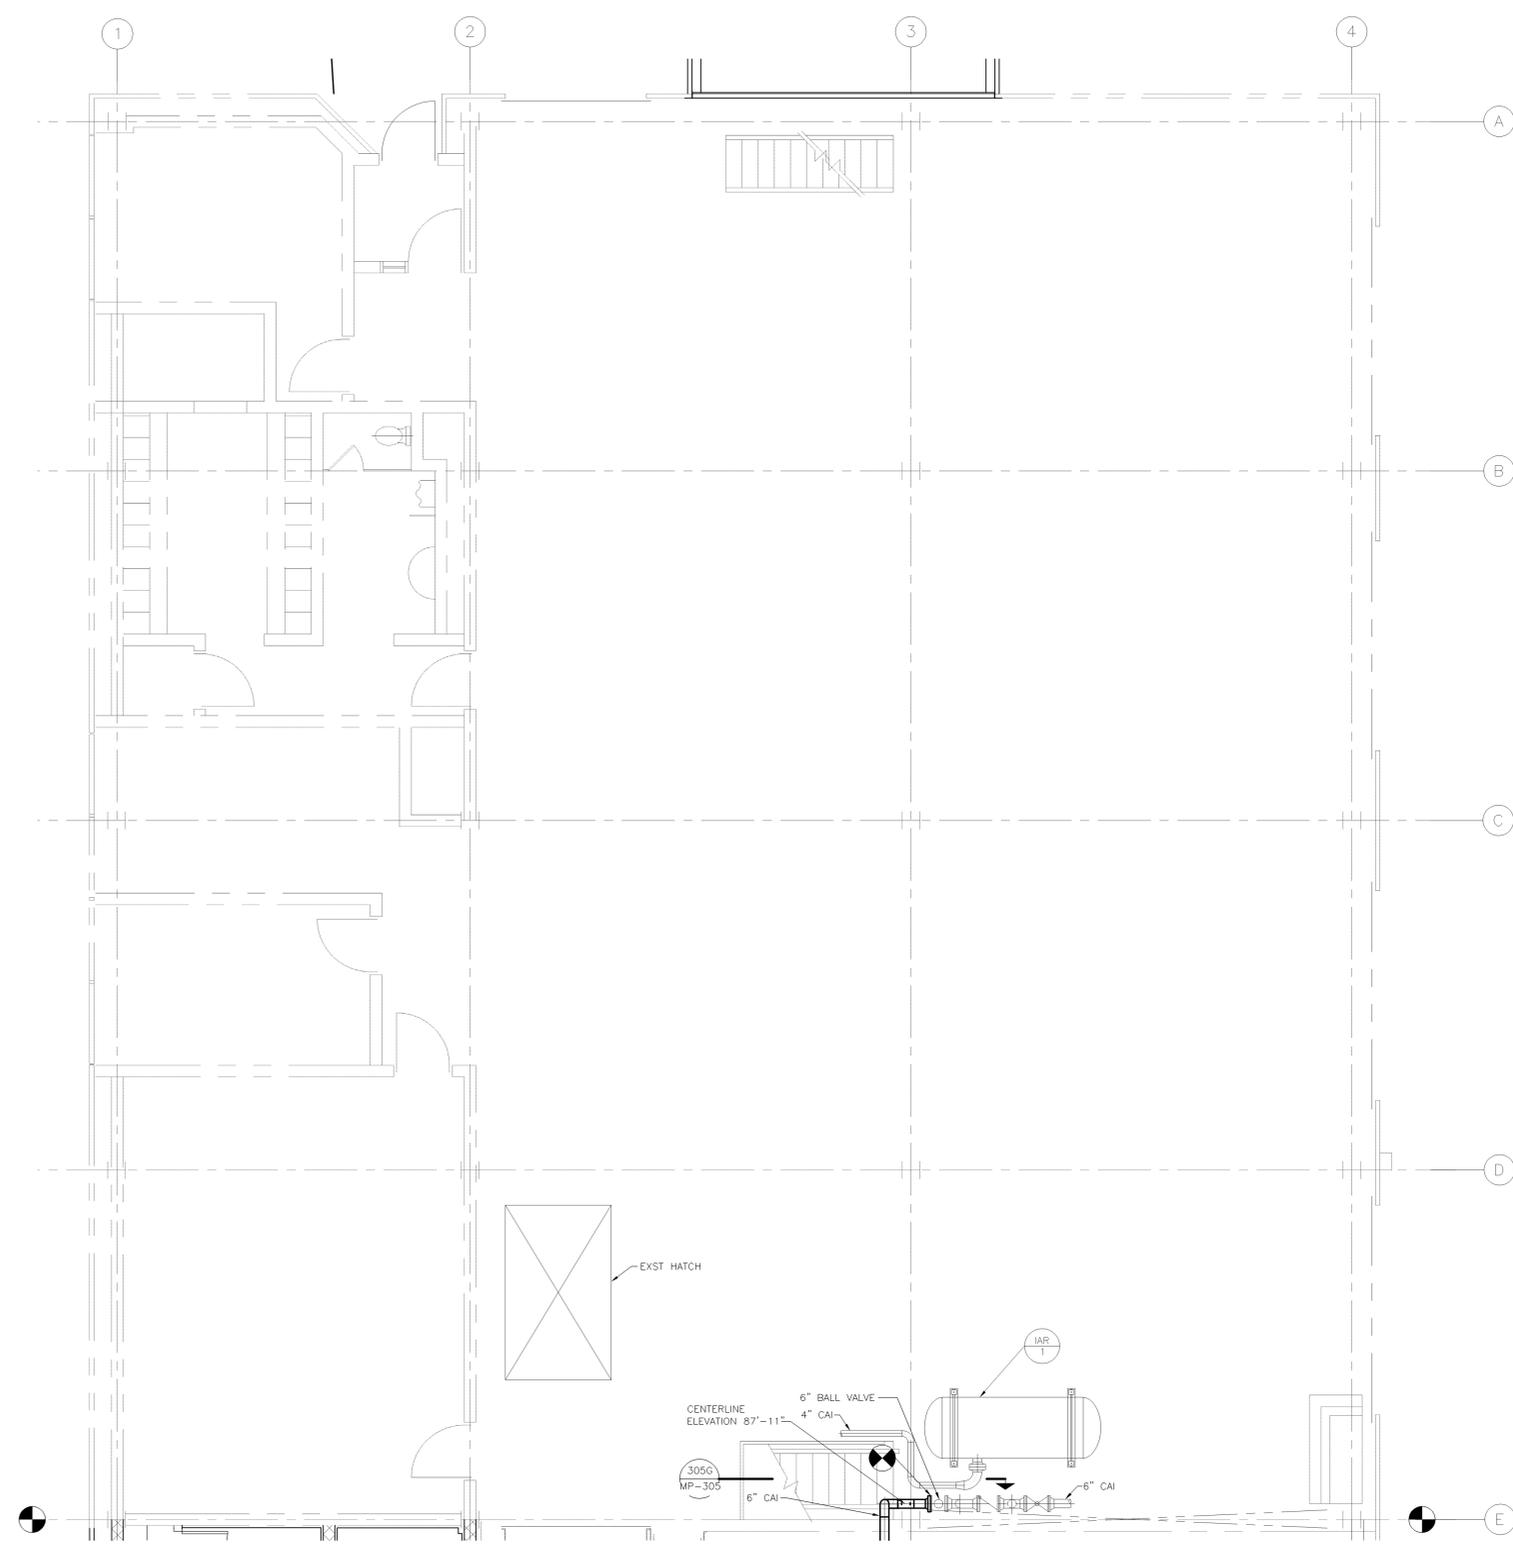

MATCHLINE MP-102

**BUILDING 600**  
**101A OPERATING FLOOR PIPING PLAN**  
 1/4" = 1'-0" FIN FL EL = 77'-0"

This drawing has been prepared solely for the use of Brookhaven National Laboratory and there are no representations of any kind made by Giffels, Partnership to any party with whom Giffels, Partnership has not entered into a contract.

This drawing shall not be used for construction purposes until the seal and signature of the responsible registrant appears on the drawing, and proper permit forms and related fees are transmitted by the Owner, Owner's Agent or Contractor to the Authority Having Jurisdiction.

LEGEND

—	EXISTING
—	NEW
- - - -	FUTURE

NOTE:  
 1. FOR PIPE SUPPORT DETAILS SEE DRAWING M-004 AND MP-500.

**Giffels, Partnership**  
 25200 Telegraph Road, Suite 200  
 Southfield, Michigan 48033 USA  
 Tel: 248-936-8000  
 Fax: 248-936-8111

Approved By: B. NEWMAN  
 Project Manager: G. KAPLAN  
 Project Engineer/Architect: E. PIENDEL  
 Project No.: SF070003

JOB NO. SHEET NO. REVISION		DATE	ENR.	APPR.	DLA
<b>BROOKHAVEN NATIONAL LABORATORY</b>					
UNDER CONTRACT WITH <b>UNITED STATES DEPARTMENT OF ENERGY</b> PLANT ENGINEERING DIVISION UPTON, NEW YORK 11973					
JOB TITLE CENTRAL CHILLED WATER FACILITY PHASE II			DWG. TITLE OPERATING FLOOR PIPING PLAN		
IR/APP/INH. NEW	DATE	ACCT. NO.	SHEET OF		
SCALE 1/4"=1'-0"	DWN. BY EP	REV'D BY BN	JOB NO. 11705	DWG. NO.	
ESHD RISK LEVEL	APPR. BY W HARRISON	BLDG. NO. 600	MP-101		
PATH:					