
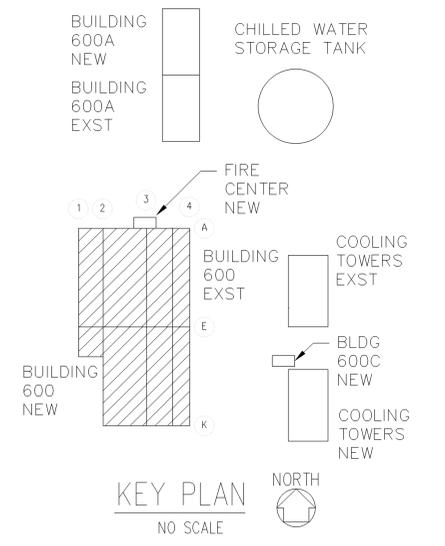


Date (mm dd yyyy)	Issued For	Rev.
12-07-2007	TITLE II DESIGN 30% REVIEW SUBMITTAL	C
03-28-2008	TITLE II DESIGN 60% REVIEW SUBMITTAL	D
07-31-2008	TITLE II DESIGN 90% REVIEW SUBMITTAL	E
08-25-2008	TITLE II DESIGN 100% OWNER REVIEW	F
02-19-2009	TITLE II CONSTRUCTION BID ISSUE	0
08-03-2009	REVIEW MODIFIED PER ADDENDUM 2	L
08-26-2009	MODIFIED PER ADDENDUMS 2 AND 3	1

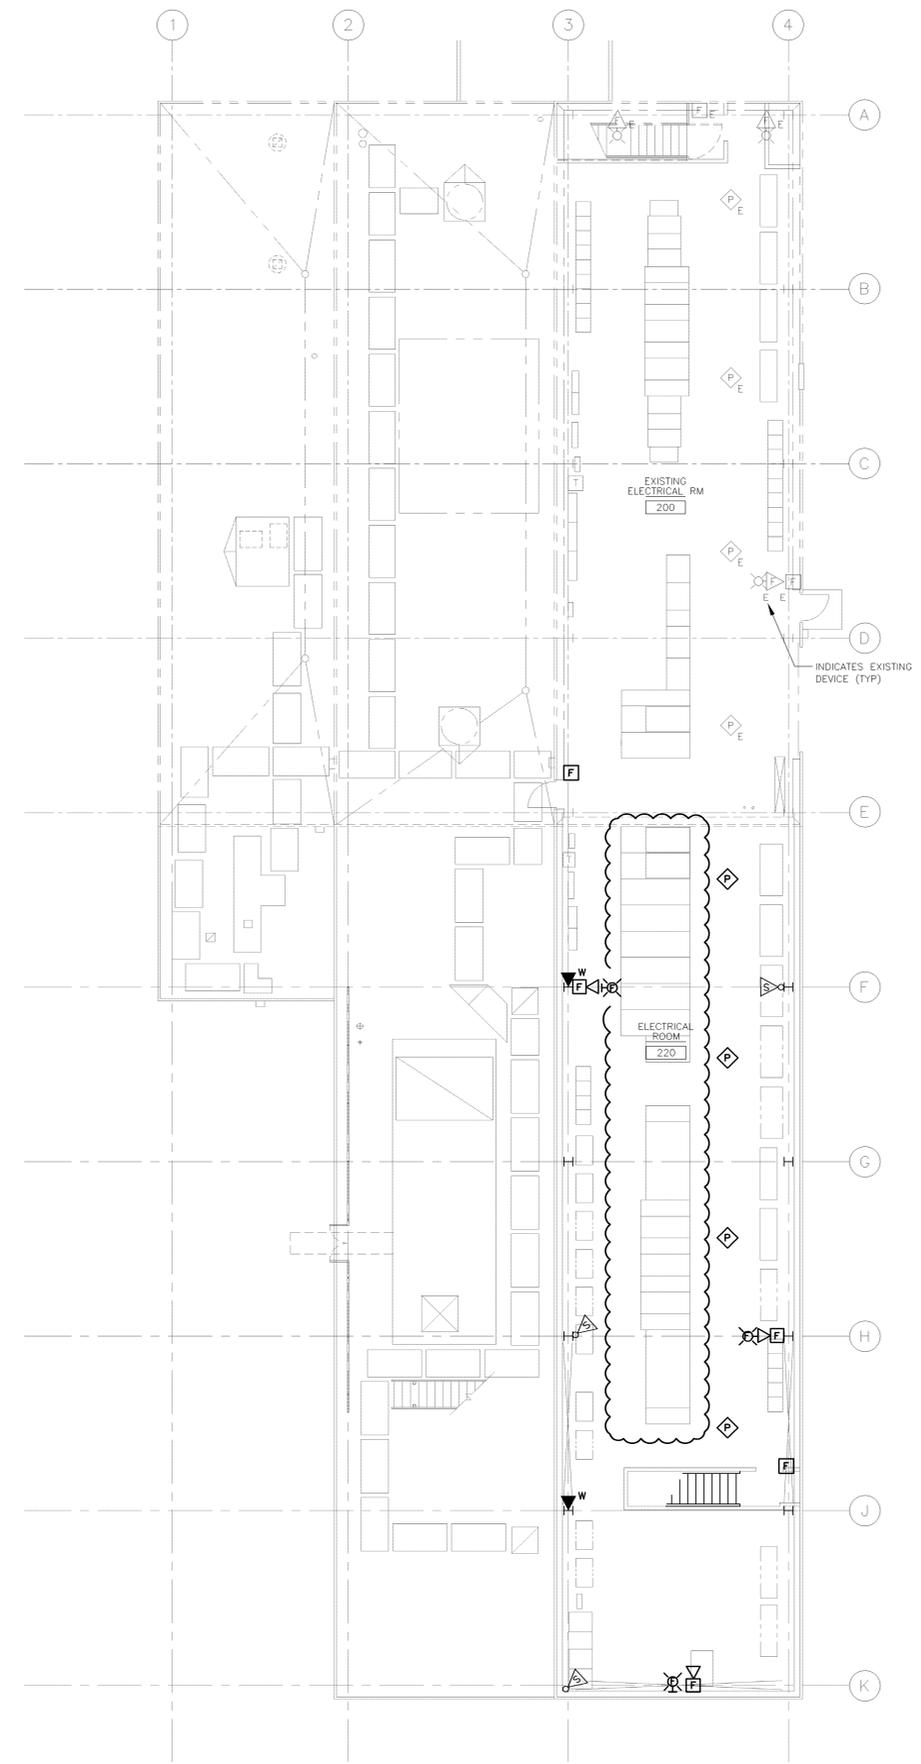

- AUXILIARY SYSTEM GENERAL NOTES:**
1. REFER TO DRAWING E-001 FOR ELECTRICAL ABBREVIATIONS, GENERAL NOTES AND DRAWING LIST AND DRAWING E-002 FOR ELECTRICAL SYMBOLS.
 2. SEE DRAWING E-608 FOR FIRE ALARM RISER DIAGRAM.
 3. SEE DRAWING E-609 FOR PAGING SYSTEM RISER DIAGRAM.
 4. SEE DRAWING E-611 FOR TELEPHONE SYSTEM RISER DIAGRAM.
 5. SEE DRAWING E-506 FOR AUXILIARY SYSTEM DETAILS.
 6. COORDINATE MOUNTING HEIGHTS OF FIRE ALARM DEVICES AND PAGING SPEAKERS WITH MECHANICAL PIPING AND EQUIPMENT. COORDINATE ANY MOUNTING OBSTRUCTION WITH OWNER REPRESENTATIVE. TYPICAL FOR FLOOR LEVEL.

This drawing has been prepared solely for the use of Brookhaven National Laboratory and there are no representations of any kind made by Giffels, Partnership to any party with whom Giffels, Partnership has not entered into a contract.

This drawing shall not be used for construction purposes until the seal and signature of the responsible registrant appears on the drawing, and proper permit forms and related fees are transmitted by the Owner, Owner's Agent or Contractor to the Authority Having Jurisdiction.

It is a violation of New York State Law Article 7209 for any person, unless he is acting under the direction of a licensed professional engineer or land surveyor, to alter in any way, if an item bearing the seal of an engineer or land surveyor is altered, the altering engineer or land surveyor shall affix to the item his seal and the notation "altered by" followed by his signature and the date of such alteration, and a specific description of the alteration.

BUILDING 600 AUX SYS ELECTRICAL RM
1/8"=1'-0"

Giffels, Partnership
25200 Telegraph Road, Suite 200
Southfield, Michigan 48033 USA
Tel: 248-936-8000
Fax: 248-936-8111

Approved By: R. BARTOY
Project Manager: G. KAPLAN
Project Engineer/Architect: R. WACH
Project No.: SF070003

BROOKHAVEN NATIONAL LABORATORY

UNDER CONTRACT WITH
UNITED STATES DEPARTMENT OF ENERGY
PLANT ENGINEERING DIVISION
UPTON, NEW YORK 11973

JOB TITLE: CENTRAL CHILLED WATER FACILITY PHASE II
DWG. TITLE: AUX SYS PLAN ELECTRICAL MEZZ

JOB NO.	SHEET NO.	REVISION	DATE	ENCL.	APPD.	QA

DATE	ACCT. NO.	SHEET OF
11/05	11705	

SCALE	DWG. NO.	JOB NO.	DWG. NO.
1/8" = 1'-0"	EA	RM	11705

ESHD RISK LEVEL	APPD. BY	BLDG. NO.	DWG. NO.
	R. BARTOY	600	EY-102

PATH: