





1 ELEVATOR PIT SUMP PUMP DETAIL
N.T.S.

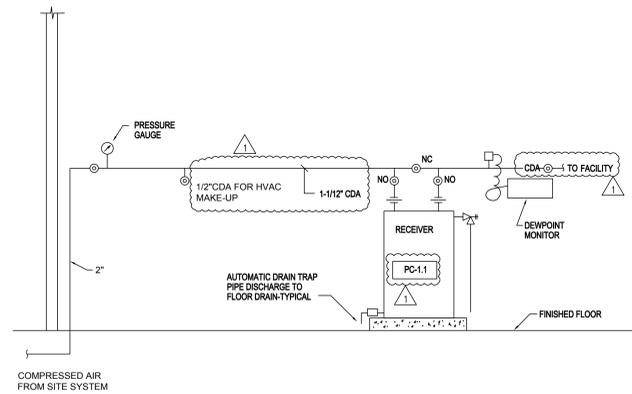

2 COMPRESSED AIR DETAIL
N.T.S.

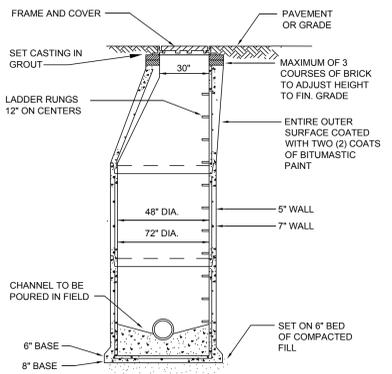


4 PRECAST CONCRETE MANHOLE DETAIL
N.T.S.

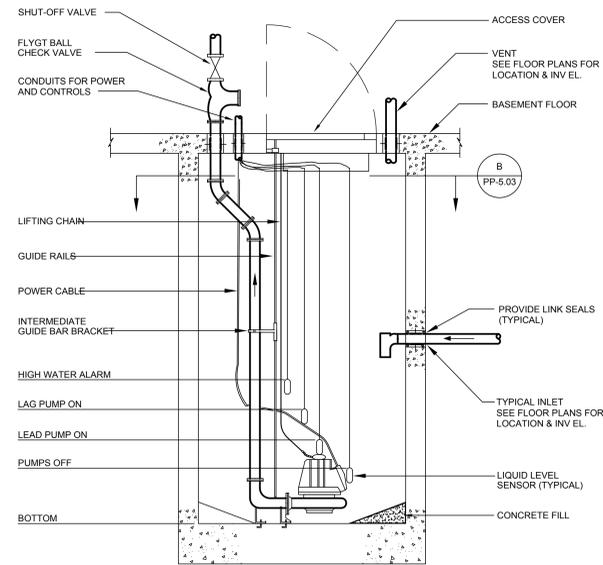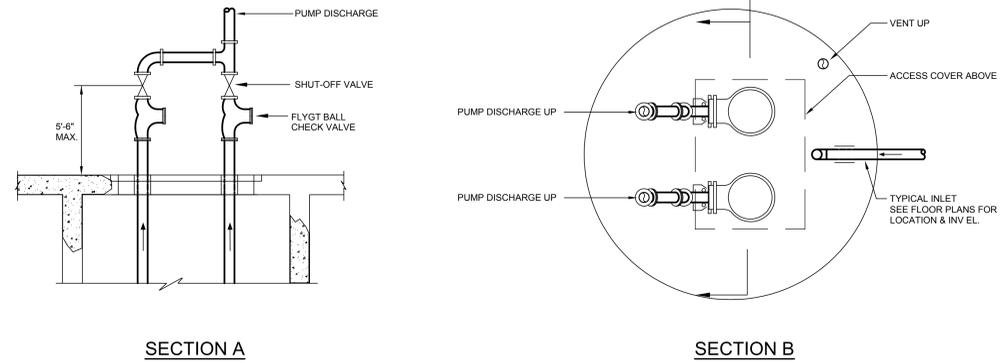


3 LIFT STATION DETAIL
N.T.S.

LIFTSTATION FLOAT CONTROL BULB ELEVATIONS						
PUMPS	PIT BOTTOM	PUMPS OFF	LEAD PUMP ON	LAG PUMP ON	HIGH WATER ALARM	REMARKS
PP-3.1	60'-0"	60'-8"	61'-6"	62'-0"	62'-6"	-
PP-3.2	60'-0"	60'-8"	61'-6"	62'-0"	62'-6"	-
PP-4.1	57'-0"	57'-8"	58'-6"	59'-0"	59'-6"	-
PP-4.2	57'-0"	57'-8"	58'-6"	59'-0"	59'-6"	-

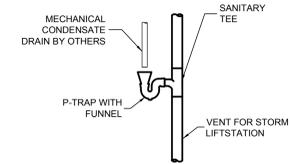

6 CONDENSATE DRAIN FUNNEL & TRAP
N.T.S.

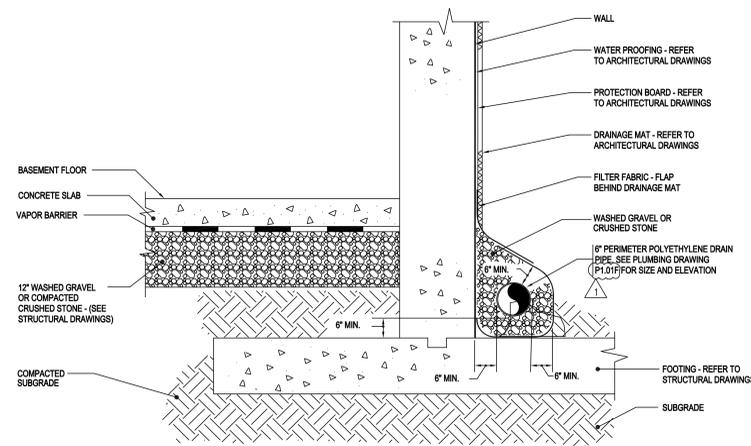

5 PERIMETER DRAIN SECTION DETAIL
NO SCALE

1		ADDENDUM #08	06/01/10
1		ISSUE FOR BID	04/09/10
JOB NO.	SHEET NO.	REVISION	DATE
<p>BROOKHAVEN NATIONAL LABORATORY</p>		UNDER CONTRACT WITH UNITED STATES DEPARTMENT OF ENERGY PLANT ENGINEERING DIVISION UPTON, NEW YORK 11973	
		JOB TITLE	DWG. TITLE
INTERDISCIPLINARY SCIENCE BUILDING		PLUMBING DETAILS	
DATE	10/23/09	ACCT. NO.	SHEET OF
SCALE	1/8" = 1'-0"	DWG. NO.	076872
FILENAME	PP-503	PP-503	